



CORNER VIEW


<p>CLIENT</p> <p>Mr. SHARAZ CHEEMA</p>	<p>PROJECT</p> <p>Nurain Welfare Trust JAMIA MASJID, HASNAIN KAREEMAIN</p>	<p>TITLE</p> <p>TITLE PAGE</p> <p>ADDRESS MOHALLAH SULTANPURA, BEHIND SCIENCE COLLEGE, (NEAR MASJID EID GAH) G. T. ROAD, GUJRAT .</p>	<p>DRAWN BY</p> <p>ALI</p> <p>REF. NO.</p> <p>TAQ. MES.</p> <p>DATE</p> <p>02 FEB. 2026.</p> <p>SHEET SCALE</p> <p>1/8" = 1'-0"</p>	<p>DRG. NO.</p> <p>CHKD. BY</p> <p>TAUQIR IQBAL</p>	<p>FIRM</p> <p>TAUQIR IQBAL & ASSOCIATES ARCHITECTS - ENGINEERS- PLANNERS 902/B, Q - BLOCK, MODEL TOWN EXT. LAHORE. CELL NO. - 0300- 6402017</p>
---	---	---	---	---	---

LEGEND

SYMBOLS	NAMES	MOUNTING HIGHT	SYMBOLS	NAMES	MOUNTING HIGHT
	C.F CEILING FAN	CEILING		CHEN CHENDLIER	CEILING
	C.L CEILING LIGHT	CEILING		WL WALL LIGHT	6'-6" HT FROM F.F.L
	W.P.L WATER PROOF LIGHT	7' HT FROM F.F.L		CAM CAMERA	11' HT. FROM FFL.
	T.L TUBE LIGHT	CEILING UNDER KITCHEN CABNET		M.T.L MIRROR TUBE LIGHT	TOP OF MIRROR AT 7'-0" HT.
	SP SPEAKER	10'-0" HT FROM F.F.L		2.P 2 PIN PLUG 5AMP	1' HT FROM F.F.L
	3P 3 PIN PLUG 5AMP	1' HT FROM F.F.L		2.P 2 PIN PLUG 5AMP	3'-6" HT FROM F.F.L BATH'S, KITCHEN AND FRIDGE
	3.P 3 PIN PLUG 15AMP	8'-6" HT FROM F.F.L FOR SPLIT A/C		WW WALL WASHER	7'-0" HT FROM F.F.L
	B BELL	8'-6" HT FROM F.F.L		B.P.S BELL PUSH SWITCH	3'-6" HT & ON GATE PILLER
	S.B SWITCH	3'-6" HT FROM F.F.L		DL DROPE LIGHT	CEILING
	TP TELEPHONE	1'-0" HT FROM F.F.L		CCL CONCELLED CEILING LIGHT	CEILING
	SP SPOT L8IGHT	AS PER PLAN		DC DOROCOM	1' HT FROM F.F.L
	A/C SPLIT A/C	8'-6" HT FROM F.F.L		EN EATHER NET	1' HT FROM F.F.L
	CAB. A/C CABINET A/C	1'-0" HT FROM F.F.L		E/F EXHAUST FAN	9' HT FROM F.F.L
	A.P ANTINA POINT	1" HT FROM F.F.L		CP CABLE POINT	1' HT FROM F.F.L
	M.D.B MAIN DISTRIBUTION BOARD	3'-6" HT FROM F.F.L		BF BRACKET FAN	8'-6" HT FROM F.F.L


NOTE:
ALL SWITCH BOARD TO BE AT 3'-6" HT
AND PLACED AT 6" FROM DOOR FRAME EDGE.

CLIENT Mr. SHARAZ CHEEMA	PROJECT Nurain Welfare Trust JAMIA MASJID, HASNAIN KAREEMAIN	TITLE ELECTRICAL LEGEND	DRAWN BY ALI	DRG. NO. E - 01	FIRM TAUQIR IQBAL & ASSOCIATES ARCHITECTS - ENGINEERS- PLANNERS 902/B, Q - BLOCK, MODEL TOWN EXT. LAHORE. CELL NO. - 0300- 6402017
		ADDRESS MOHALLAH SULTANPURA, BEHIND SCIENCE COLLEGE, (NEAR MASJID EID GAH) G. T. ROAD, GUJRAT .	REF. NO. TAQ. MES.	DATE 02 FEB. 2026.	
			SHEET SCALE 1/8" = 1'-0"		

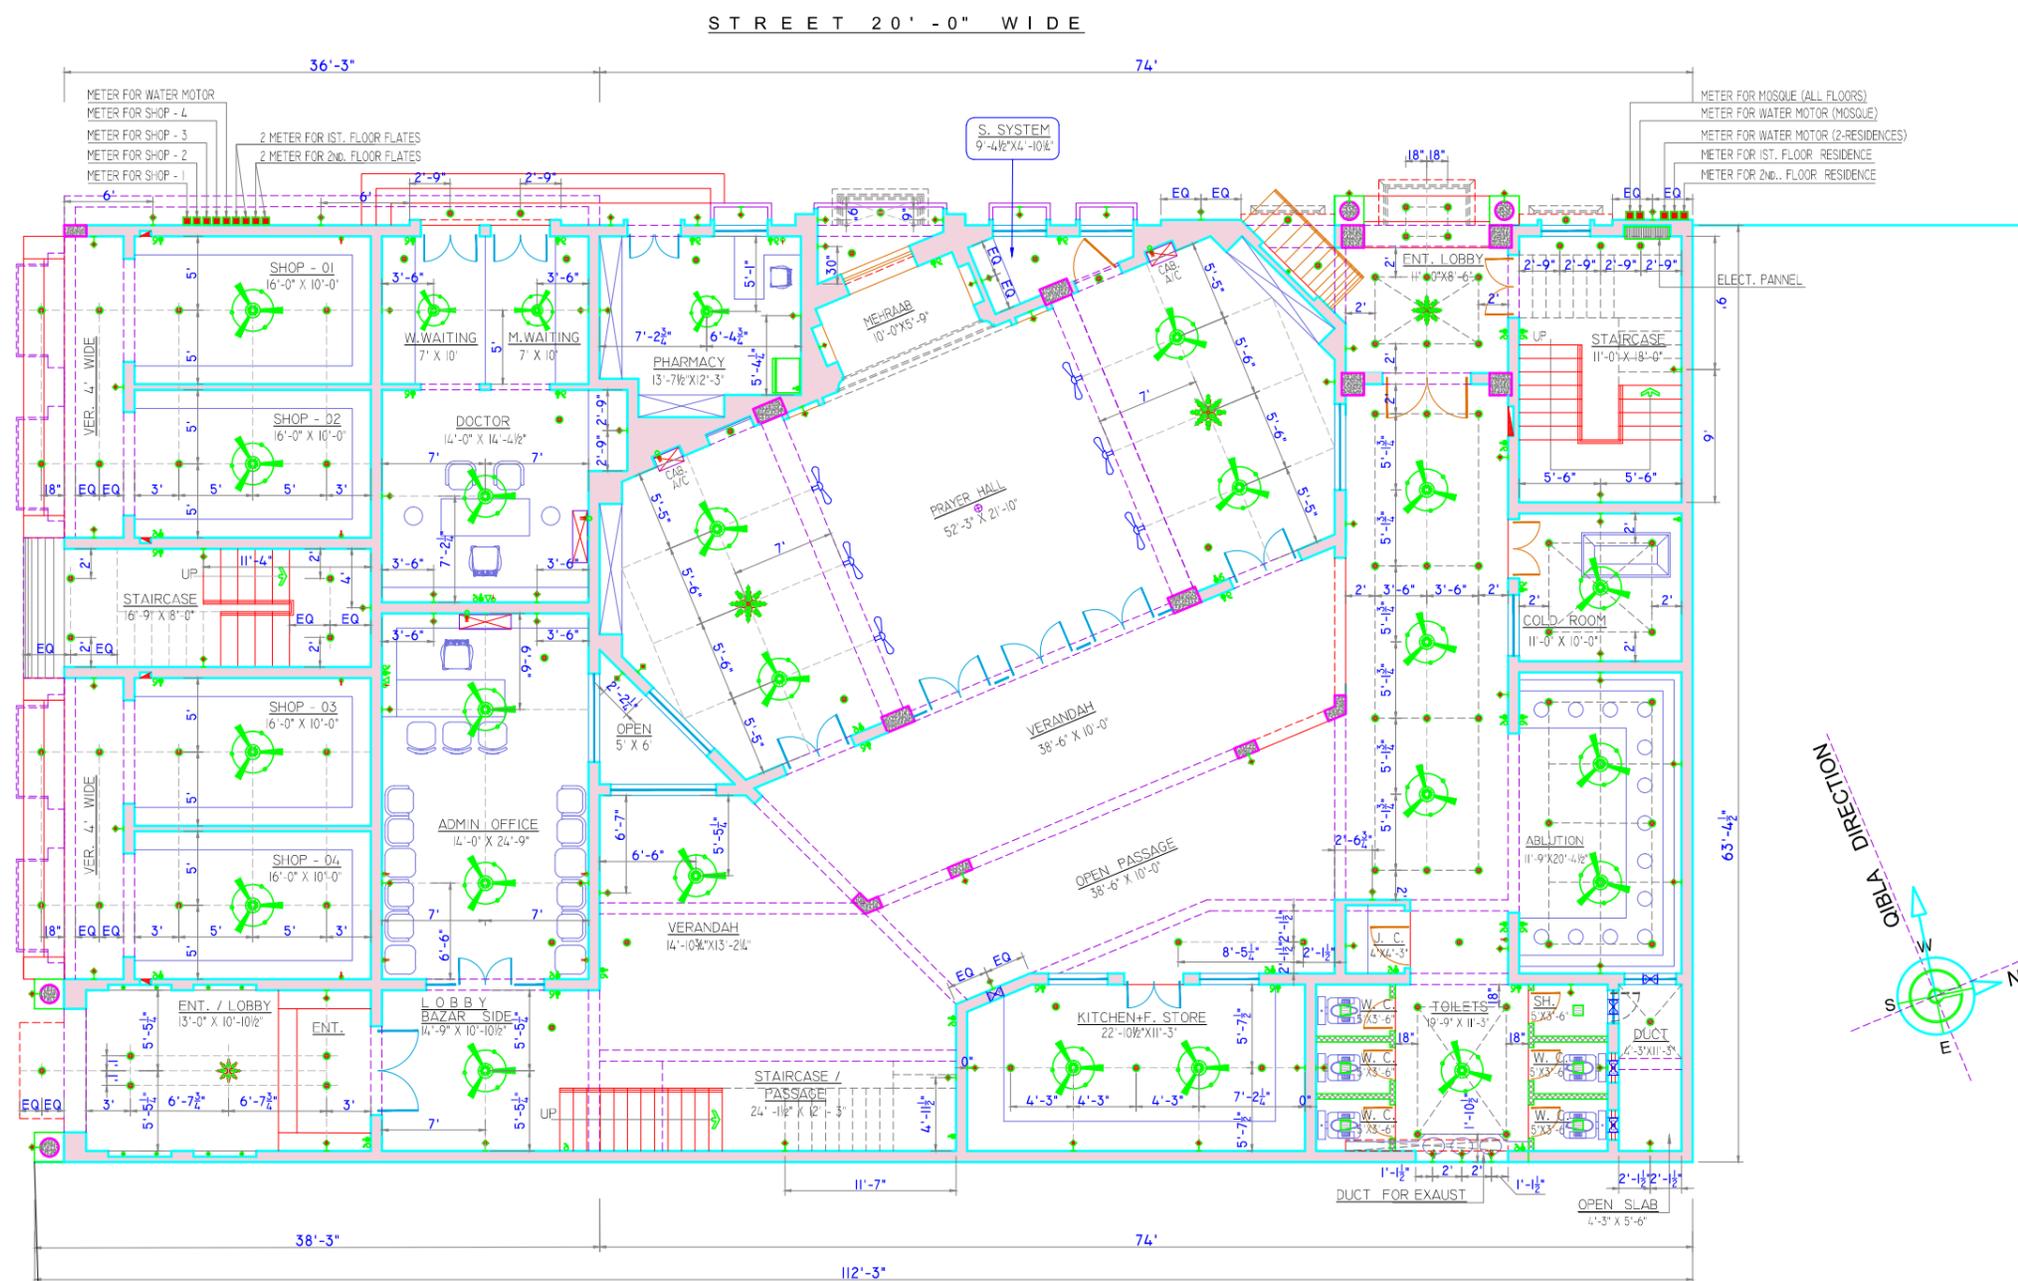


**GROUND FLOOR
ELECTRICAL LAYOUT PLAN**
SCALE : 1" = 8'-0"

CLIENT Mr. SHARAZ CHEEMA	PROJECT Nurain Welfare Trust JAMIA MASJID, HASNAIN KAREEMAIN	TITLE GROUND FLOOR ELECTRICAL LAYOUT PLAN	DRAWN BY ALI	DRG. NO. E - 02	FIRM TAUQIR IQBAL & ASSOCIATES ARCHITECTS - ENGINEERS- PLANNERS 902/B, Q - BLOCK, MODEL TOWN EXT. LAHORE. CELL NO. - 0300- 6402017
		ADDRESS MOHALLAH SULTANPURA, BEHIND SCIENCE COLLEGE, (NEAR MASJID EID GAH) G. T. ROAD, GUJRAT .	REF. NO. TAQ. MES.	CHKD. BY TAUQIR IQBAL	
		DATE 03 FEB. 2026.	SHEET SCALE 1/8" = 1'-0"		

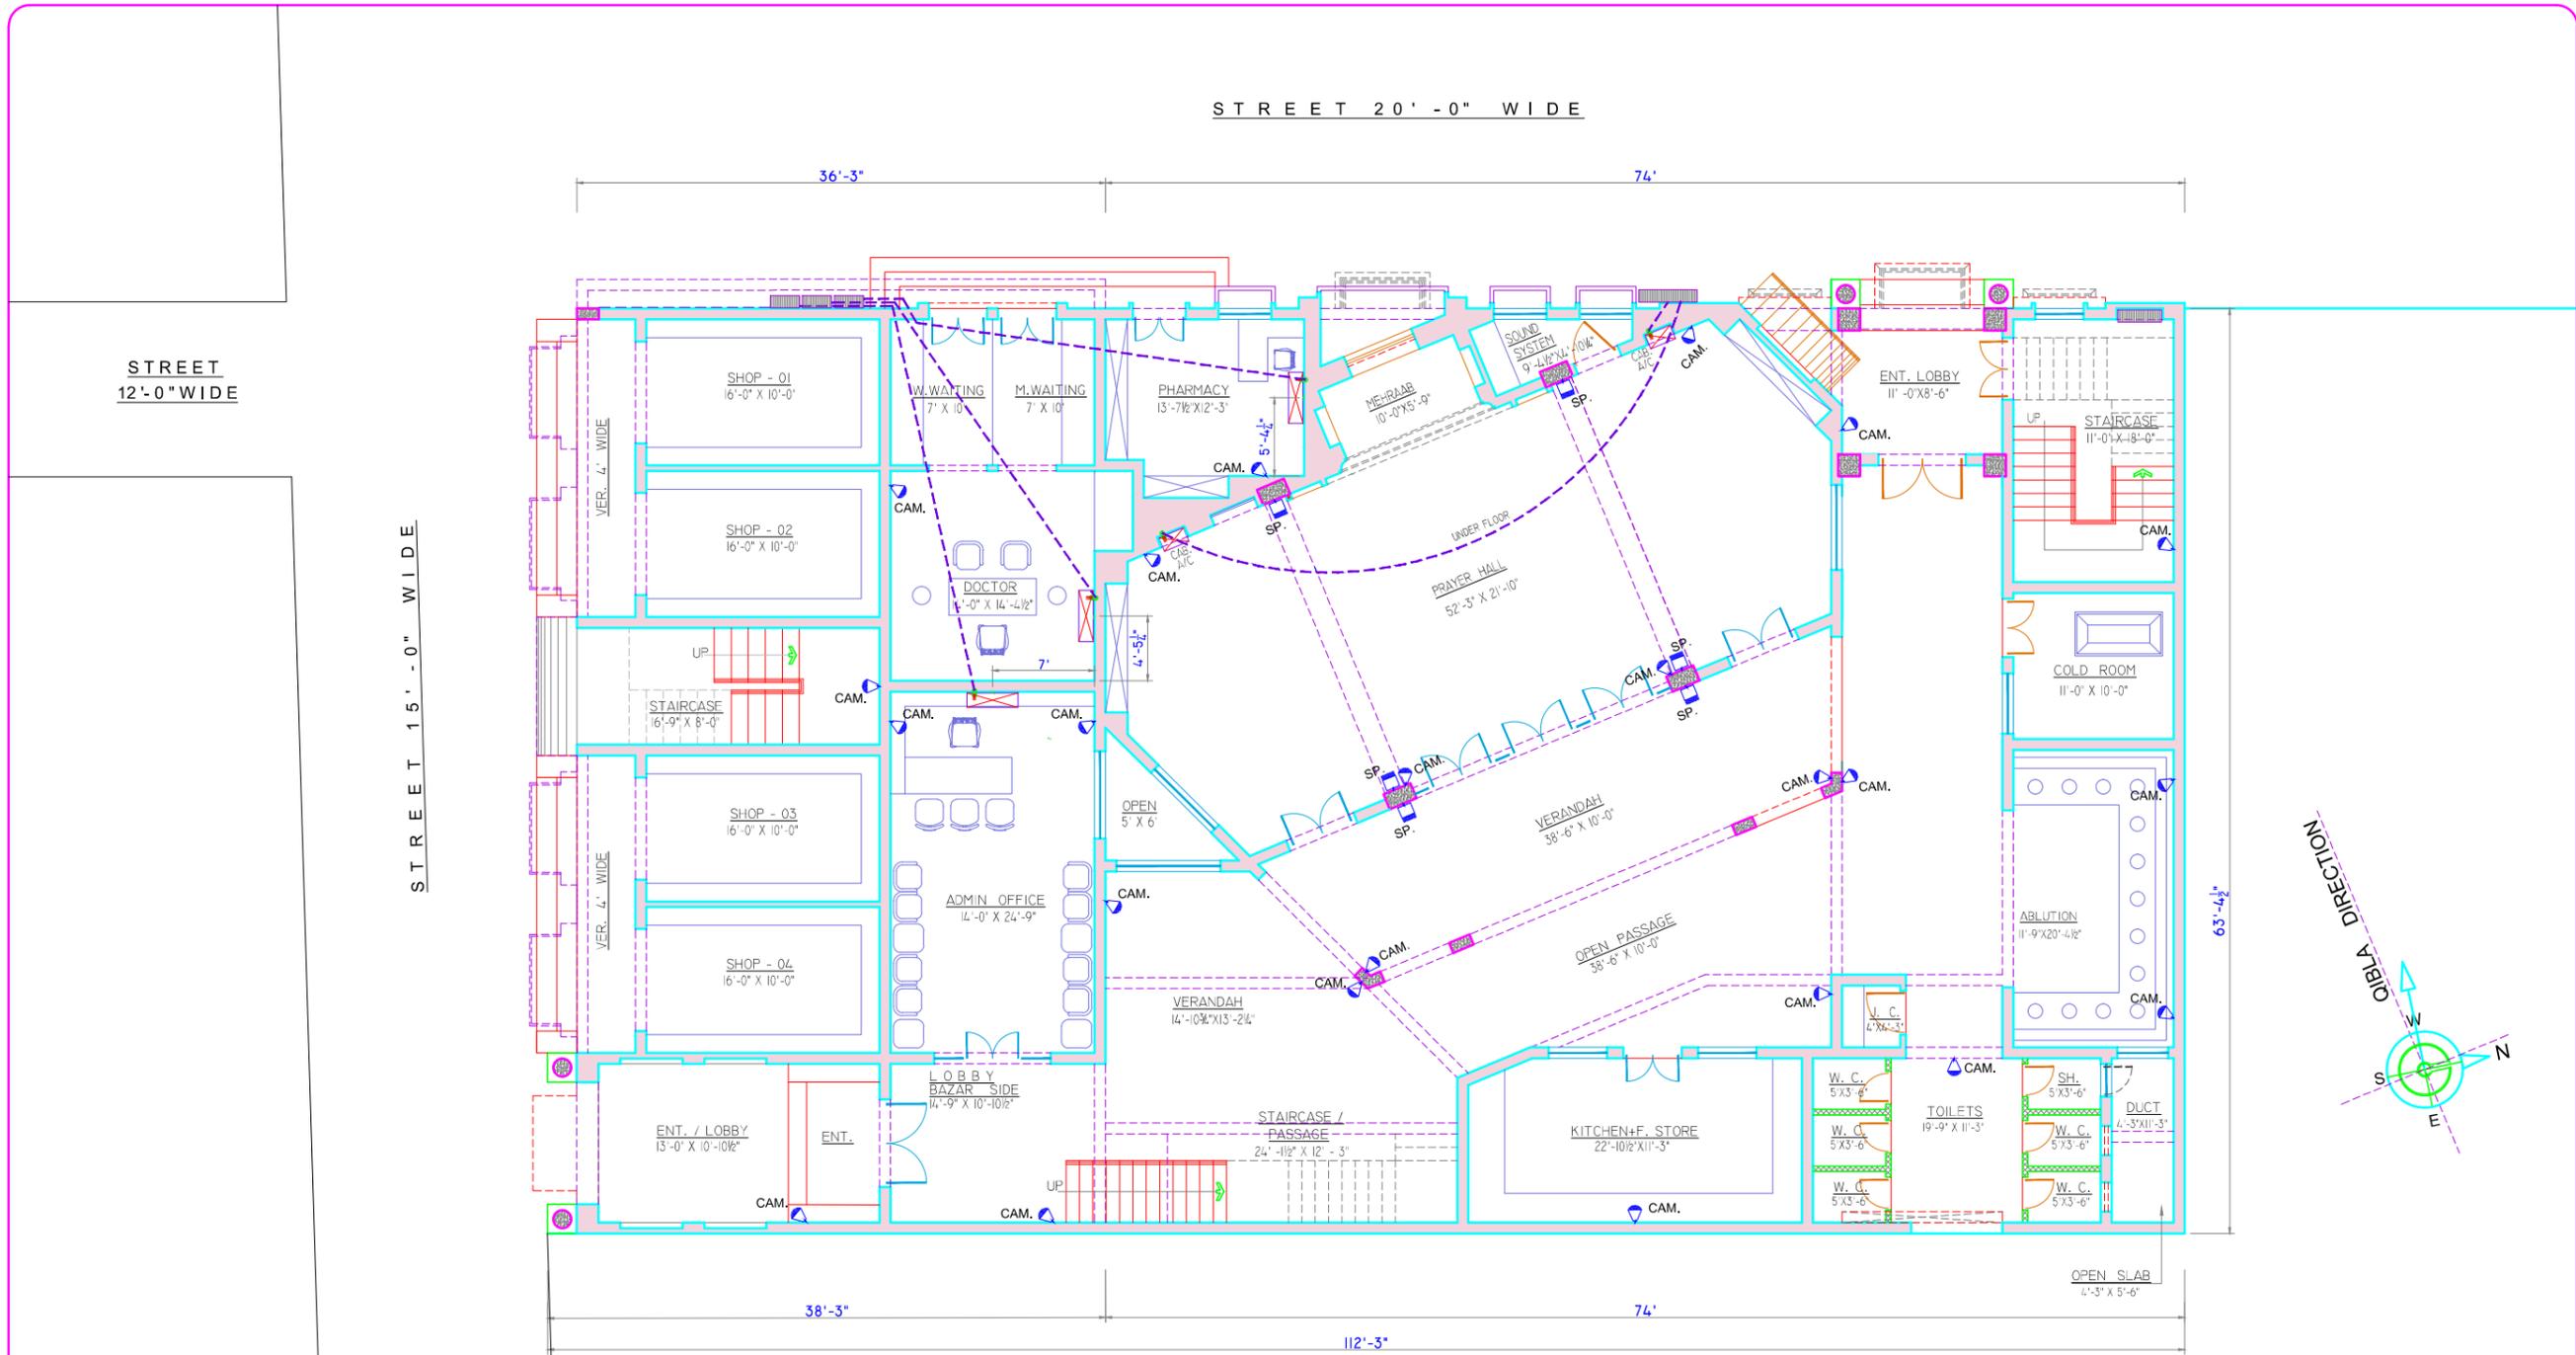

GROUND FLOOR
SPEAKER / CAMERA & A/C LAYOUT PLAN
 SCALE : 1" = 8'-0"


CLIENT	PROJECT	TITLE	DRAWN BY	DRG. NO.	FIRM
		ADDRESS	REF. NO.	CHKD. BY	
Mr. SHARAZ CHEEMA	<u>Nurain Welfare Trust</u> JAMIA MASJID, HASNAIN KAREEMAIN	GROUND FLOOR SPEAKER / CAMERA & A/C LAYOUT PLAN	ALI	E - 03	TAUQIR IQBAL & ASSOCIATES ARCHITECTS - ENGINEERS- PLANNERS 902/B, Q - BLOCK, MODEL TOWN EXT. LAHORE. CELL NO. - 0300- 6402017
		MOHALLAH SULTANPURA, BEHIND SCIENCE COLLEGE, (NEAR MASJID EID GAH) G. T. ROAD, GUJRAT .	TAQ. MES.		
			DATE	04 FEB. 2026.	

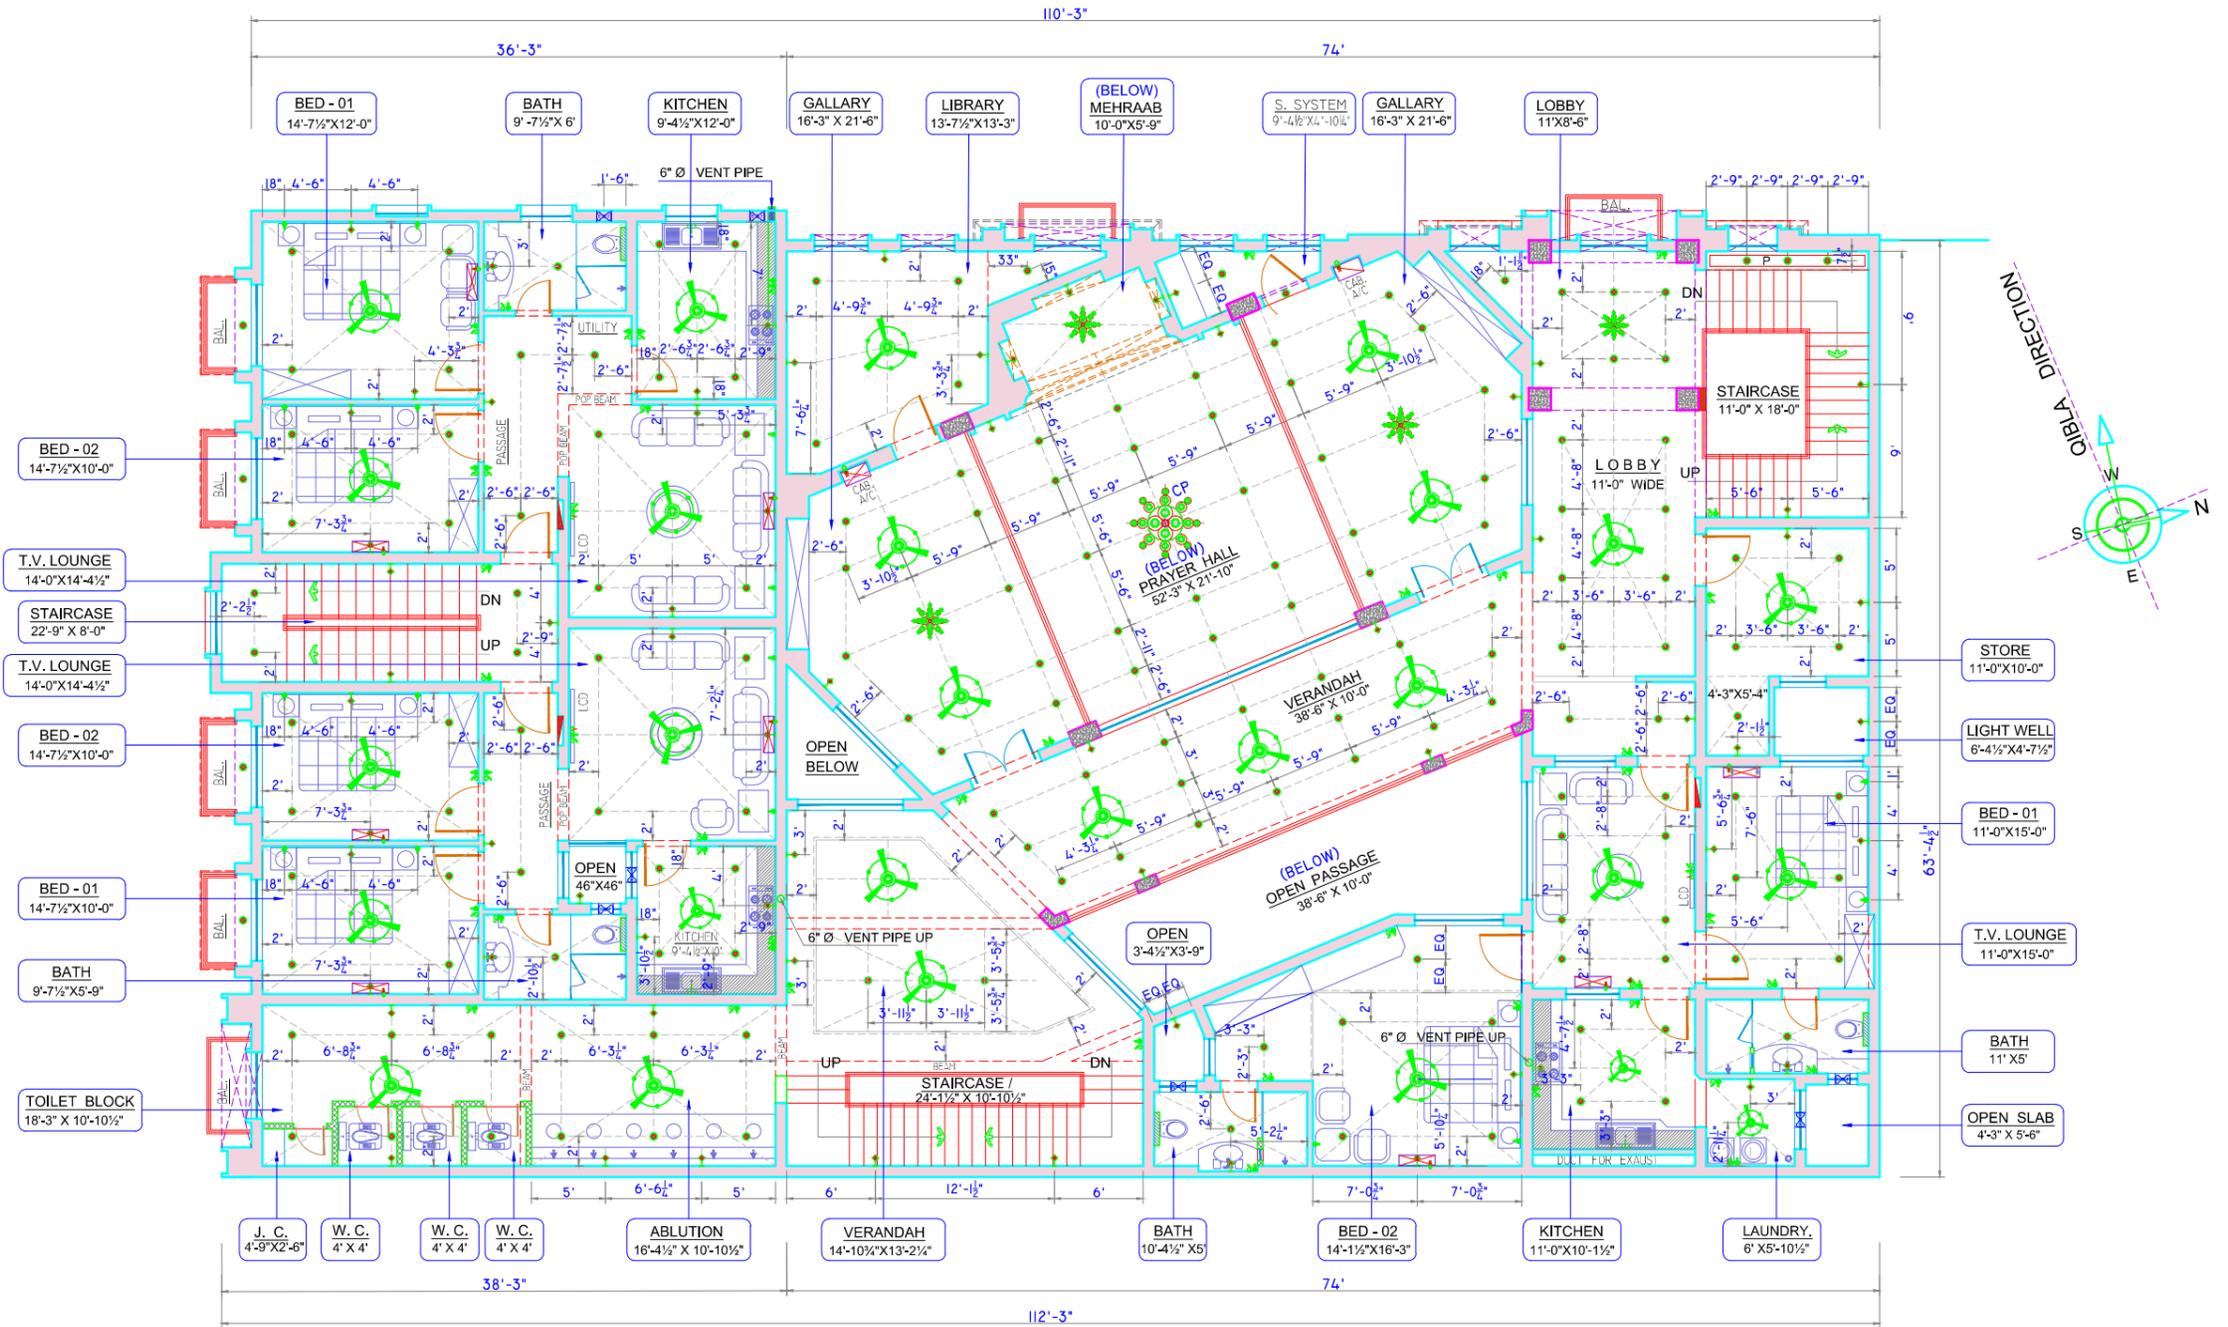

**FIRST FLOOR
ELECTRICAL LAYOUT PLAN**


SCALE : 1" = 8'-0"

CLIENT Mr. SHARAZ CHEEMA	PROJECT Nurain Welfare Trust JAMIA MASJID, HASNAIN KAREEMAIN	TITLE FIRST FLOOR ELECTRICAL LAYOUT PLAN	DRAWN BY ALI	DRG. NO. E - 04	FIRM TAUQIR IQBAL & ASSOCIATES ARCHITECTS - ENGINEERS- PLANNERS 902/B, Q - BLOCK, MODEL TOWN EXT. LAHORE. CELL NO. - 0300- 6402017
		ADDRESS MOHALLAH SULTANPURA, BEHIND SCIENCE COLLEGE, (NEAR MASJID EID GAH) G. T. ROAD, GUJRAT .	REF. NO. TAQ. MES.	CHKD. BY TAUQIR IQBAL	
		DATE 05 FEB. 2026.	SHEET SCALE 1/8" = 1'-0"		

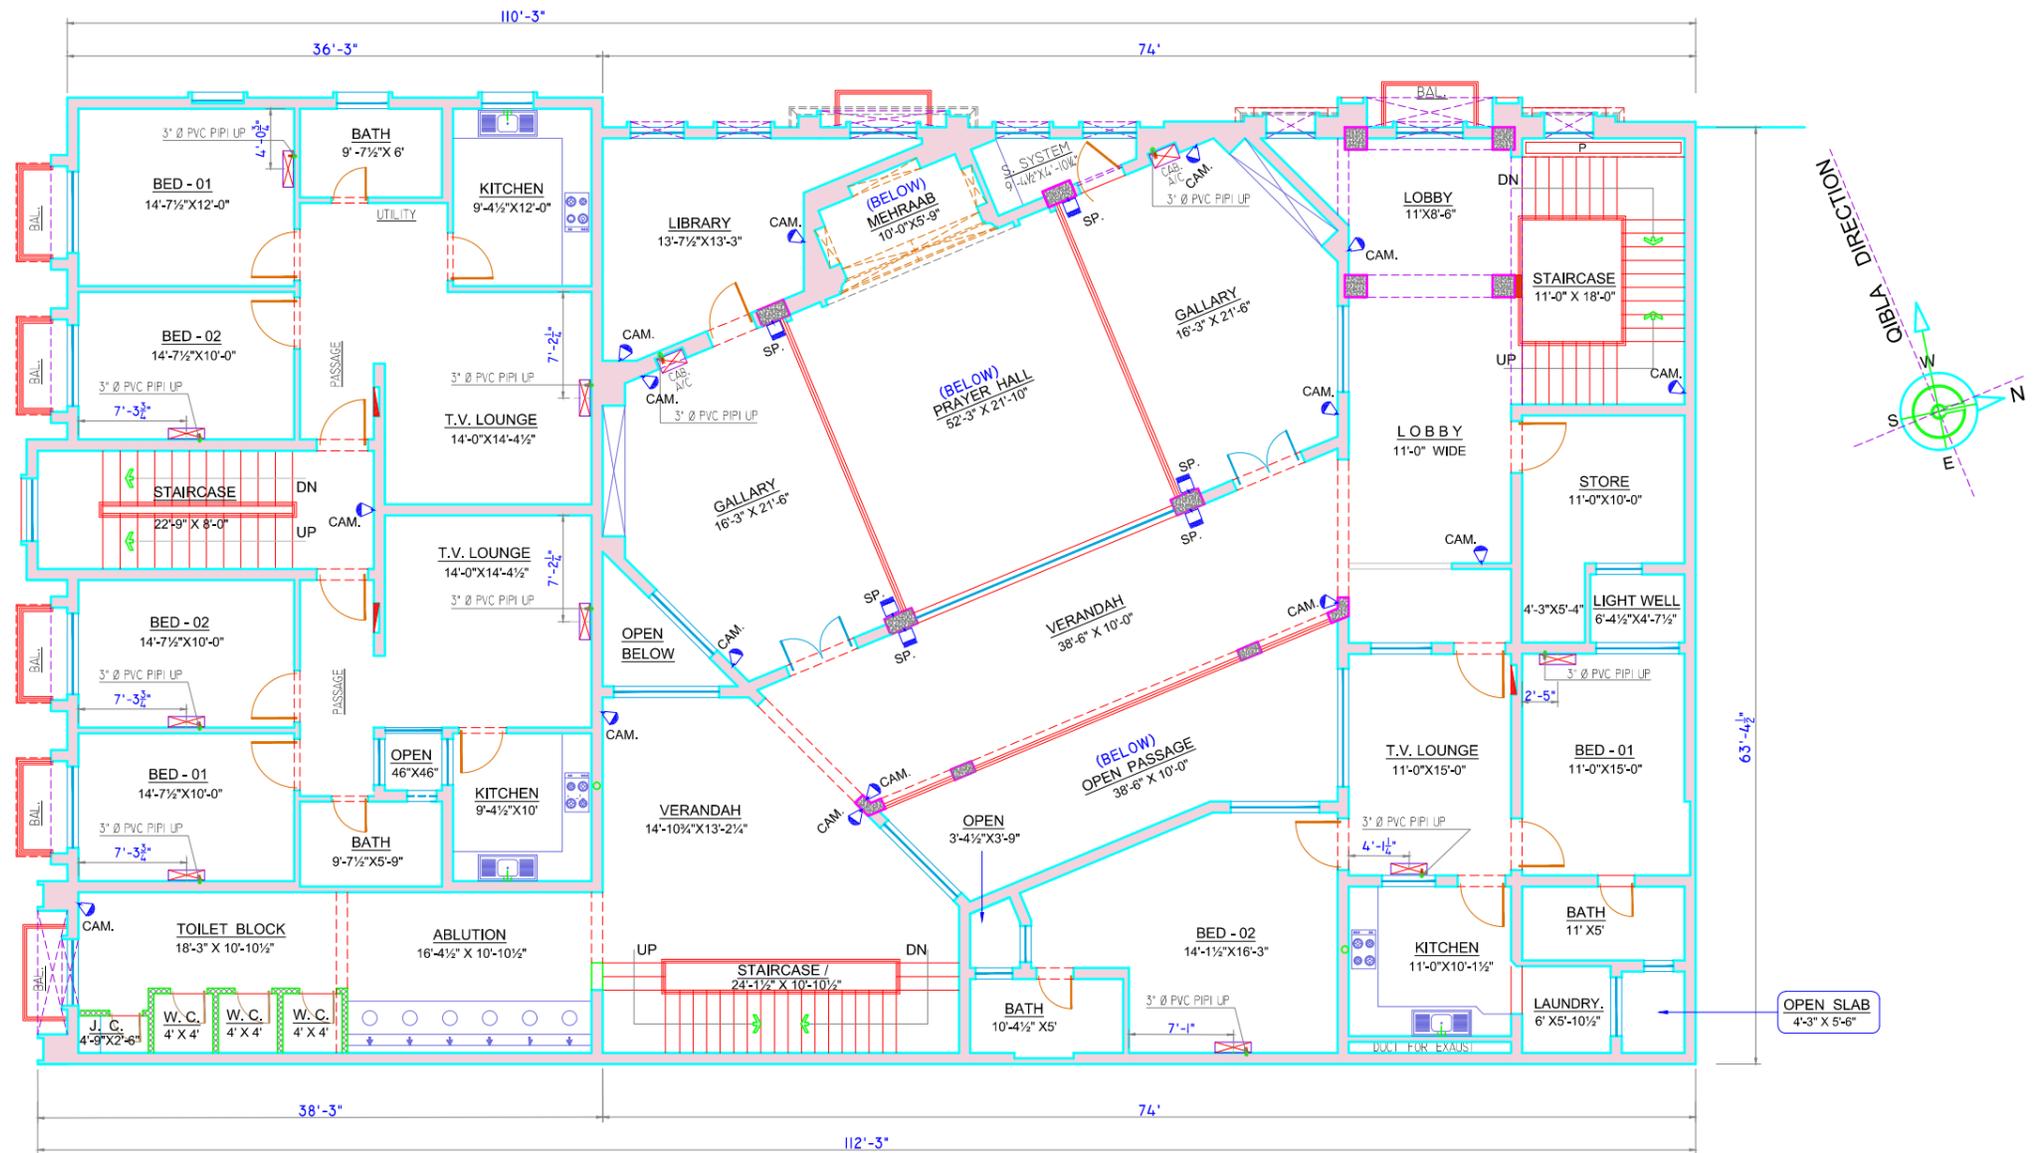


FIRST FLOOR
SPEAKER / CAMERA & A/C LAYOUT PLAN
 SCALE : 1" = 8'-0"

CLIENT Mr. SHARAZ CHEEMA	PROJECT Nurain Welfare Trust JAMIA MASJID, HASNAIN KAREEMAIN	TITLE FIRST FLOOR SPEAKER / CAMERA & A/C LAYOUT PLAN	DRAWN BY ALI	DRG. NO. E - 05	FIRM TAUQIR IQBAL & ASSOCIATES ARCHITECTS - ENGINEERS- PLANNERS 902/B, Q - BLOCK, MODEL TOWN EXT. LAHORE. CELL NO. - 0300- 6402017
		ADDRESS MOHALLAH SULTANPURA, BEHIND SCIENCE COLLEGE, (NEAR MASJID EID GAH) G. T. ROAD, GUJRAT .	REF. NO. TAQ. MES.	CHKD. BY TAUQIR IQBAL	
			DATE 06 FEB. 2026.		
			SHEET SCALE 1/8" = 1'-0"		

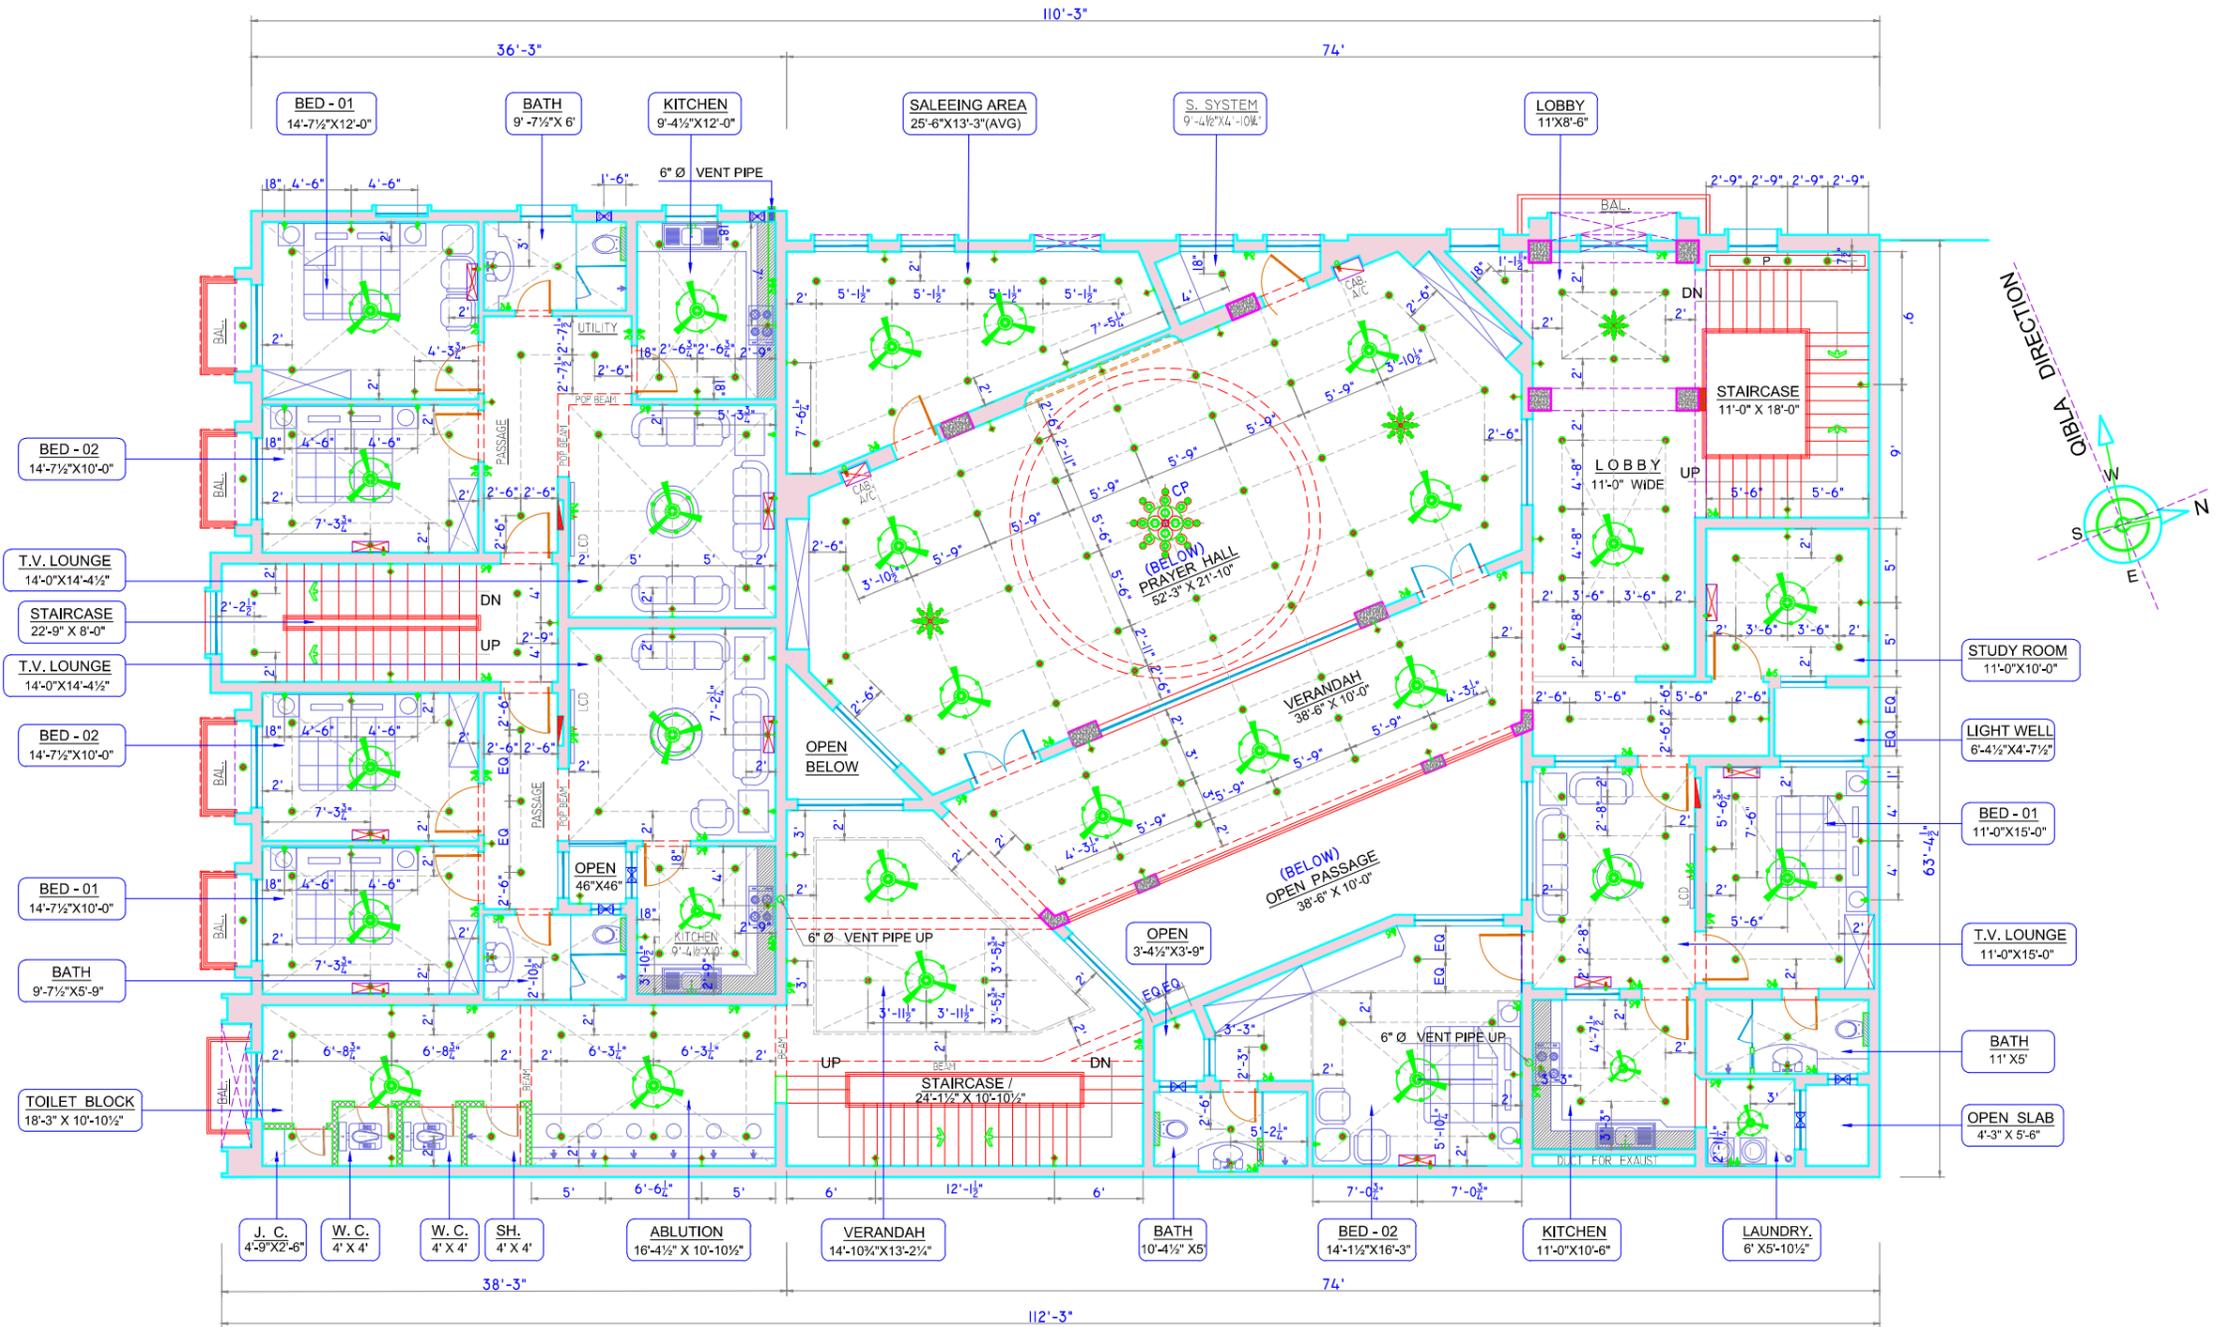


**SECOND FLOOR
ELECTRICAL LAYOUT PLAN**
SCALE : 1" = 8'-0"

CLIENT Mr. SHARAZ CHEEMA	PROJECT Nurain Welfare Trust JAMIA MASJID, HASNAIN KAREEMAIN	TITLE SECOND FLOOR ELECTRICAL LAYOUT PLAN	DRAWN BY ALI	DRG. NO. E - 06	FIRM TAUQIR IQBAL & ASSOCIATES ARCHITECTS - ENGINEERS- PLANNERS 902/B, Q - BLOCK, MODEL TOWN EXT. LAHORE. CELL NO. - 0300- 6402017
		ADDRESS MOHALLAH SULTANPURA, BEHIND SCIENCE COLLEGE, (NEAR MASJID EID GAH) G. T. ROAD, GUJRAT .	REF. NO. TAQ. MES.	CHKD. BY TAUQIR IQBAL	
		DATE 07 FEB. 2026.	SHEET SCALE 1/8" = 1'-0"		

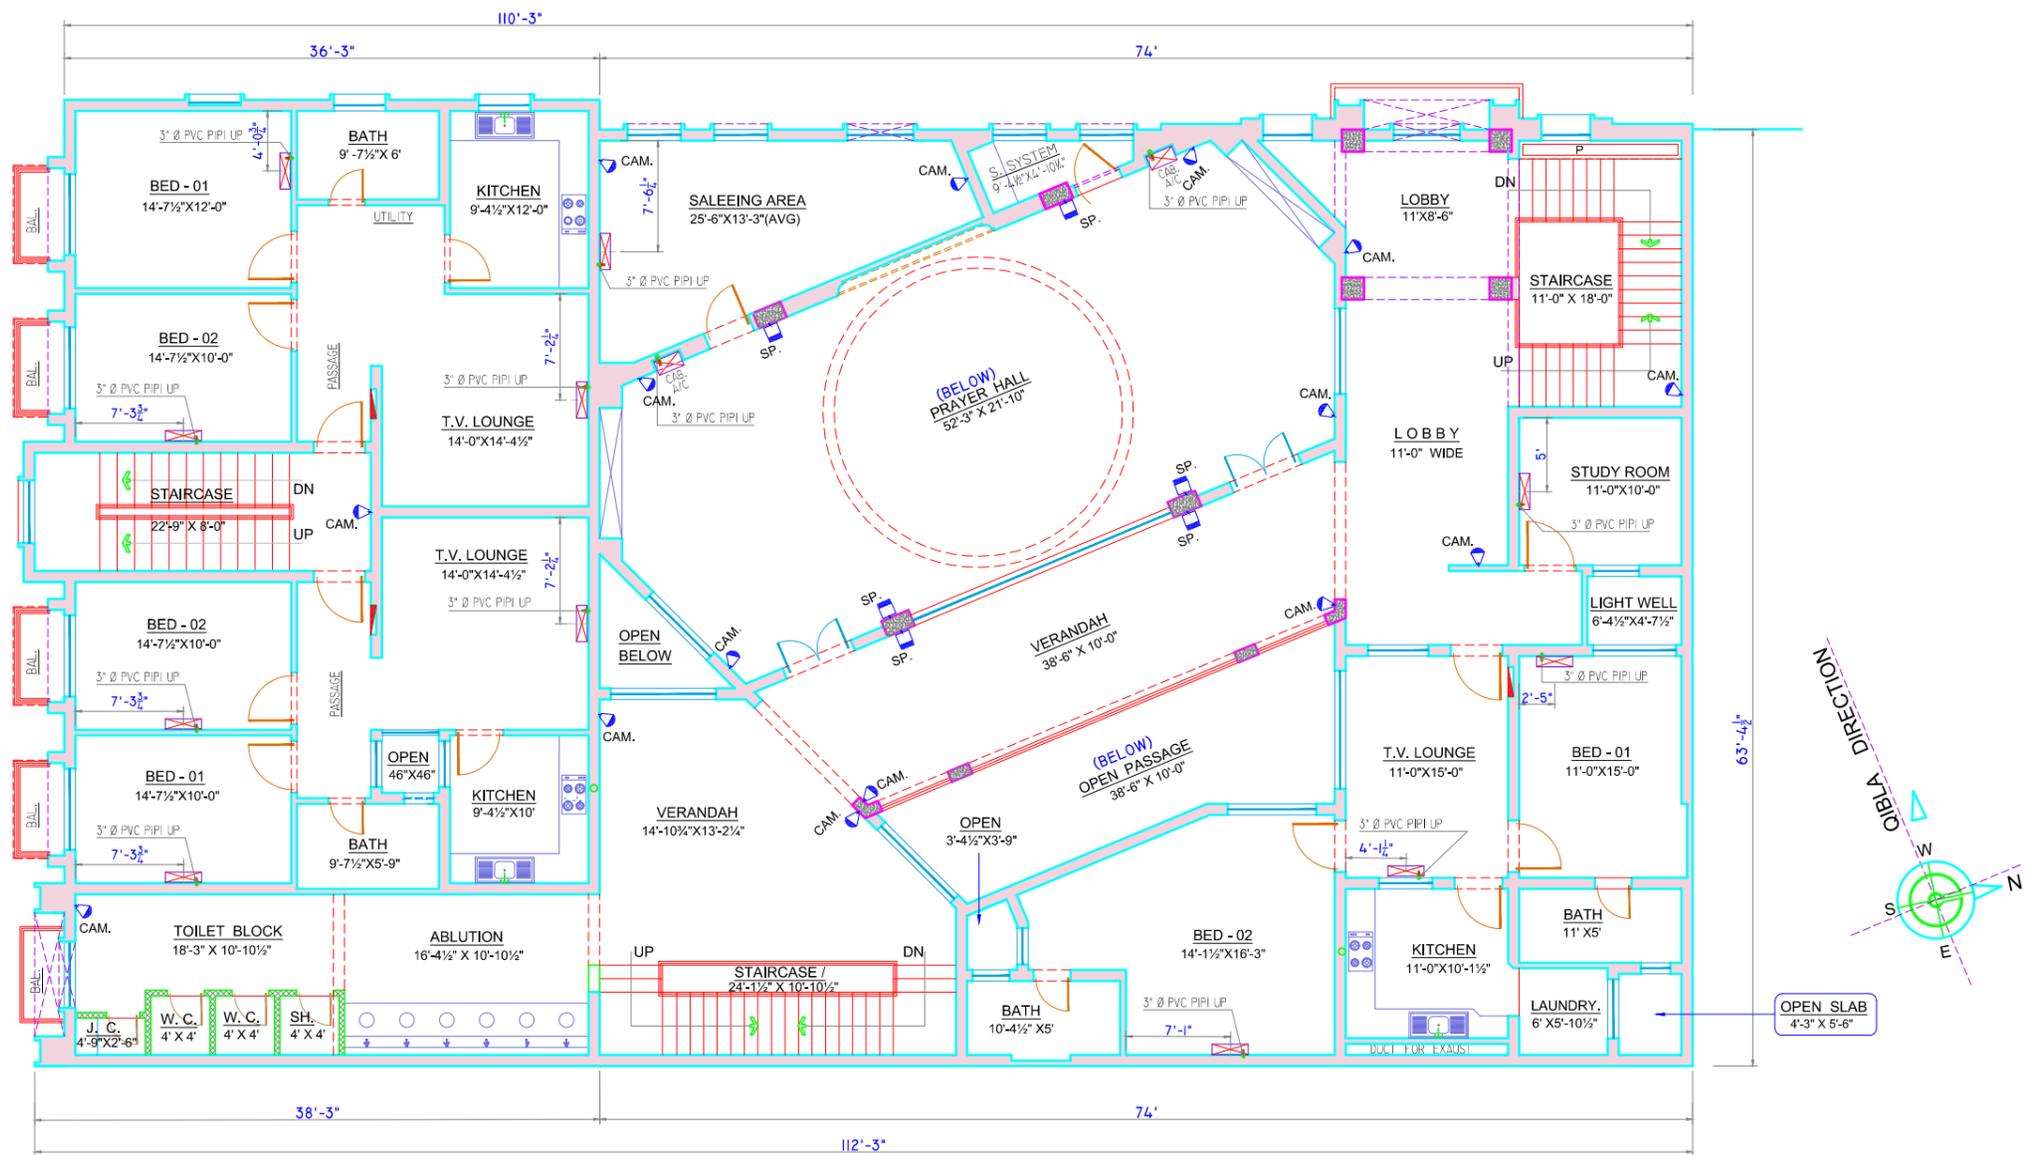

**SECOND FLOOR
SPEAKER / CAMERA & A/C LAYOUT PLAN**
SCALE : 1" = 8'-0"

CLIENT Mr. SHARAZ CHEEMA	PROJECT Nurain Welfare Trust JAMIA MASJID, HASNAIN KAREEMAIN	TITLE SECOND FLOOR SPEAKER / CAMERA & A/C LAYOUT PLAN	DRAWN BY ALI	DRG. NO. E - 07	FIRM TAUQIR IQBAL & ASSOCIATES ARCHITECTS - ENGINEERS- PLANNERS 902/B, Q - BLOCK, MODEL TOWN EXT. LAHORE. CELL NO. - 0300- 6402017
		ADDRESS MOHALLAH SULTANPURA, BEHIND SCIENCE COLLEGE, (NEAR MASJID EID GAH) G. T. ROAD, GUJRAT .	REF. NO. TAQ. MES.	CHKD. BY TAUQIR IQBAL	
			DATE 08 FEB. 2026.		
			SHEET SCALE 1/8" = 1'-0"		

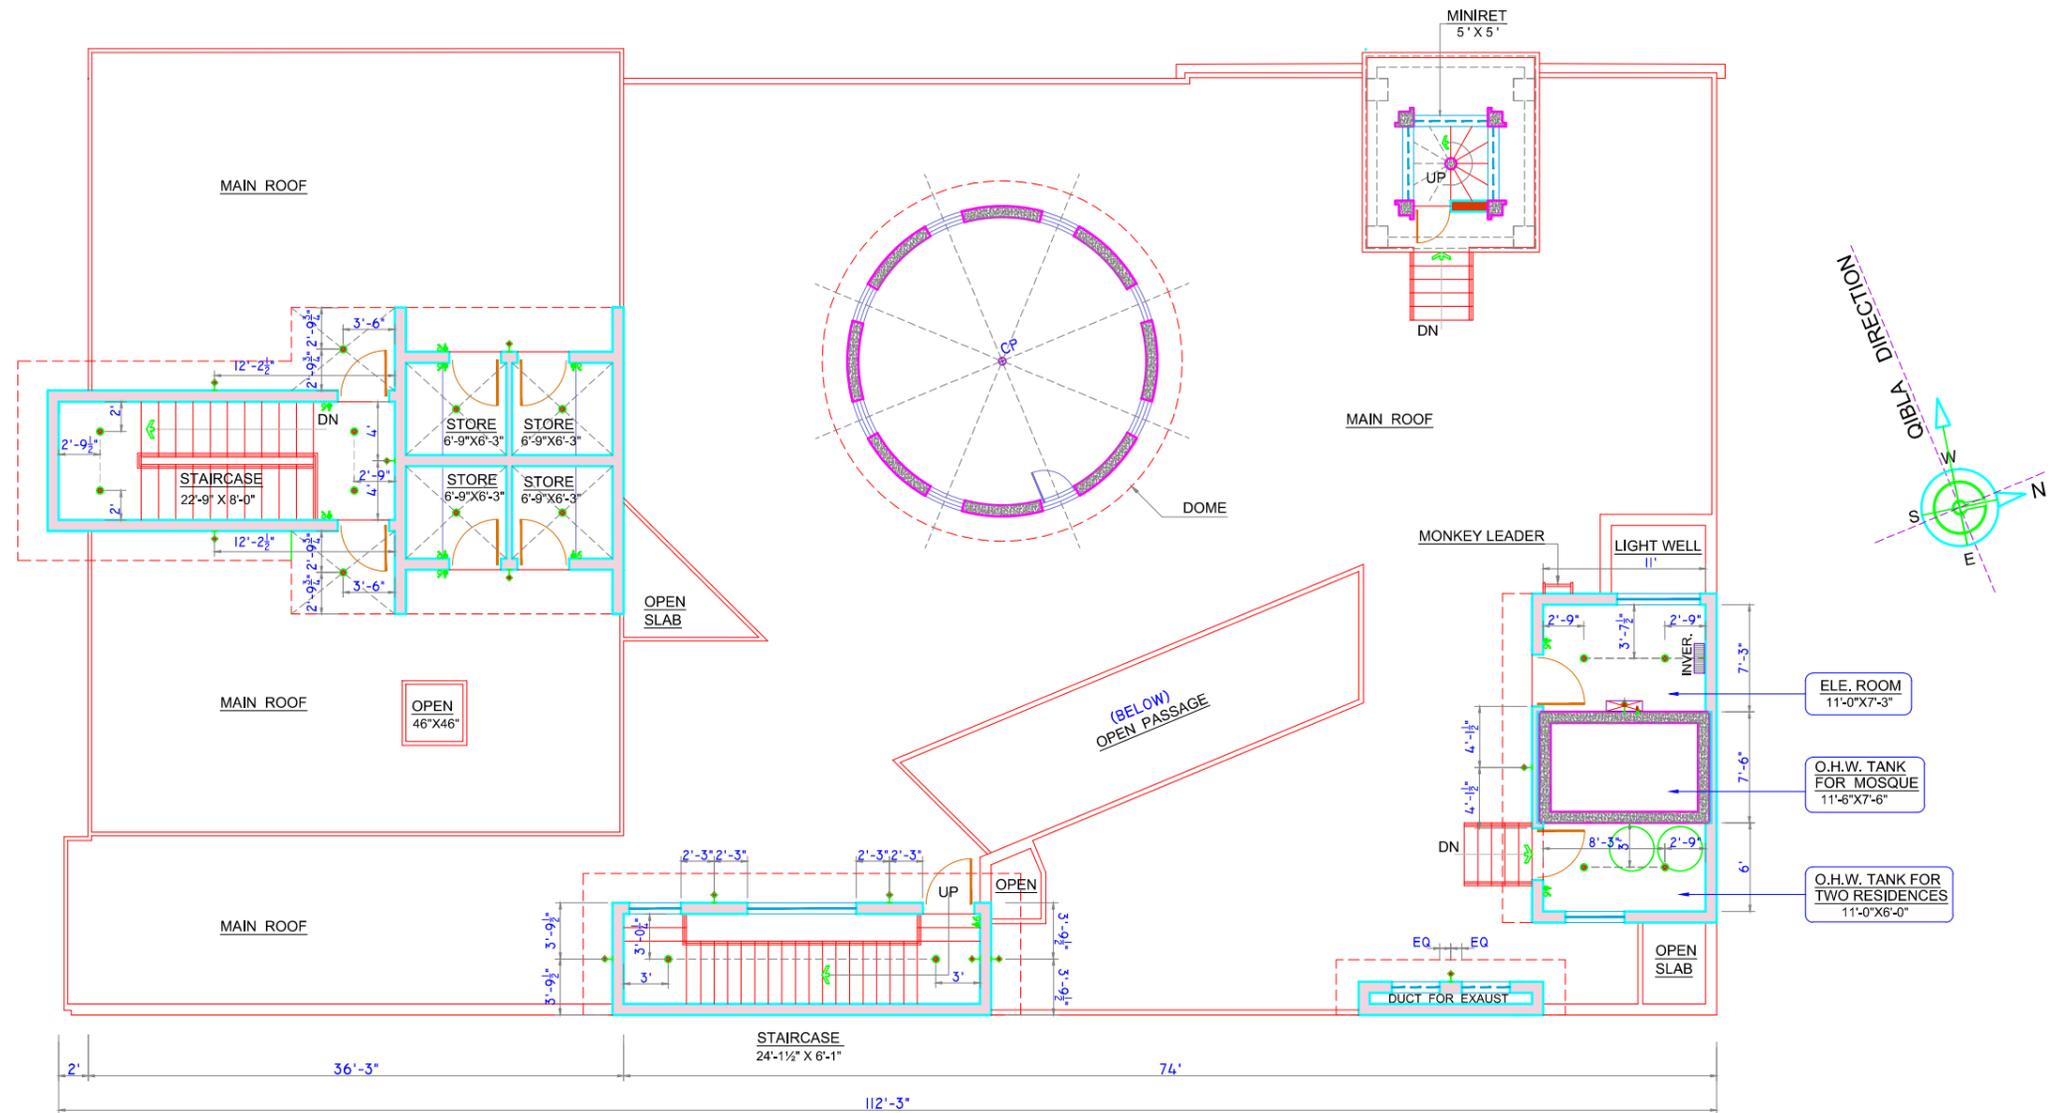

MUMTY FLOOR
ELECTRICAL LAYOUT PLAN
 SCALE : 1" = 8'-0"

CLIENT Mr. SHARAZ CHEEMA	PROJECT Nurain Welfare Trust JAMIA MASJID, HASNAIN KAREEMAIN	TITLE MUMTY FLOOR ELECTRICAL LAYOUT PLAN	DRAWN BY ALI	DRG. NO. E - 08	FIRM TAUQIR IQBAL & ASSOCIATES ARCHITECTS - ENGINEERS- PLANNERS 902/B, Q - BLOCK, MODEL TOWN EXT. LAHORE. CELL NO. - 0300- 6402017
		ADDRESS MOHALLAH SULTANPURA, BEHIND SCIENCE COLLEGE, (NEAR MASJID EID GAH) G. T. ROAD, GUJRAT .	REF. NO. TAQ. MES.	CHKD. BY	
			DATE 10 FEB. 2026.		
			SHEET SCALE 1/8" = 1'-0"	TAUQIR IQBAL	